

EXISTING PHOTOMETRIC CONTOUR ILLUMINATION PLAN

ANSWER

S A B A K , W I L S O N & L I N G O , I N C

ENGINNEERS, LANDSCAPE ARCHITECTS & PLANNERS
THE HENRY CLAY 608 S. THIRD STREET, LOUISVILLE, KENTUCKY 40202
(502) 584 - 6271

PROJECT TITLE: **TOP GOLF AT OXMOOR CENTER**
7900 SHELBYVILLE ROAD & OXMOOR LANE
LOUISVILLE, KY 40222
TD SON LOTS 1 7 8 7 AND TD 30M LOTS 50 8 51

PF
309
1"=5

05/23/1

LO.1



NEW PHOTOMETRIC CONTOUR ILLUMINATION PLAN

NEWTON

Luminaire Schedule			
Symbol	Label	Description	LLF
	T5WS	DSX0 LED XX 50K T5S MVOLT	0.900
	T5W	DSX2 LED P8 50K T5W MVOLT	0.900
	T3M	DSX2 LED P5 50K T3M MVOLT	0.900
	BLC	DSX2 LED P6 50K BLC MVOLT	0.900

CASE # 18ZONE1014

OWNER
MB 2, LLC & TWM OXMOOR 2
PO BOX 617905

APPLICANTS
TORQUE NO. 1, LOUISVILLE, K.

TOP COOL USA LOUISVILLE, KY
N. CENTRAL EXPRESSWAY, SUITE 100
DALLAS, TX 75231

60 N. ORLEANS STREET, SUIT
CHICAGO, IL 60654

PHOTOMETRIC CONTOUR


三
SHI

JOB
SCALE

DATE:
DRAW:

1

5

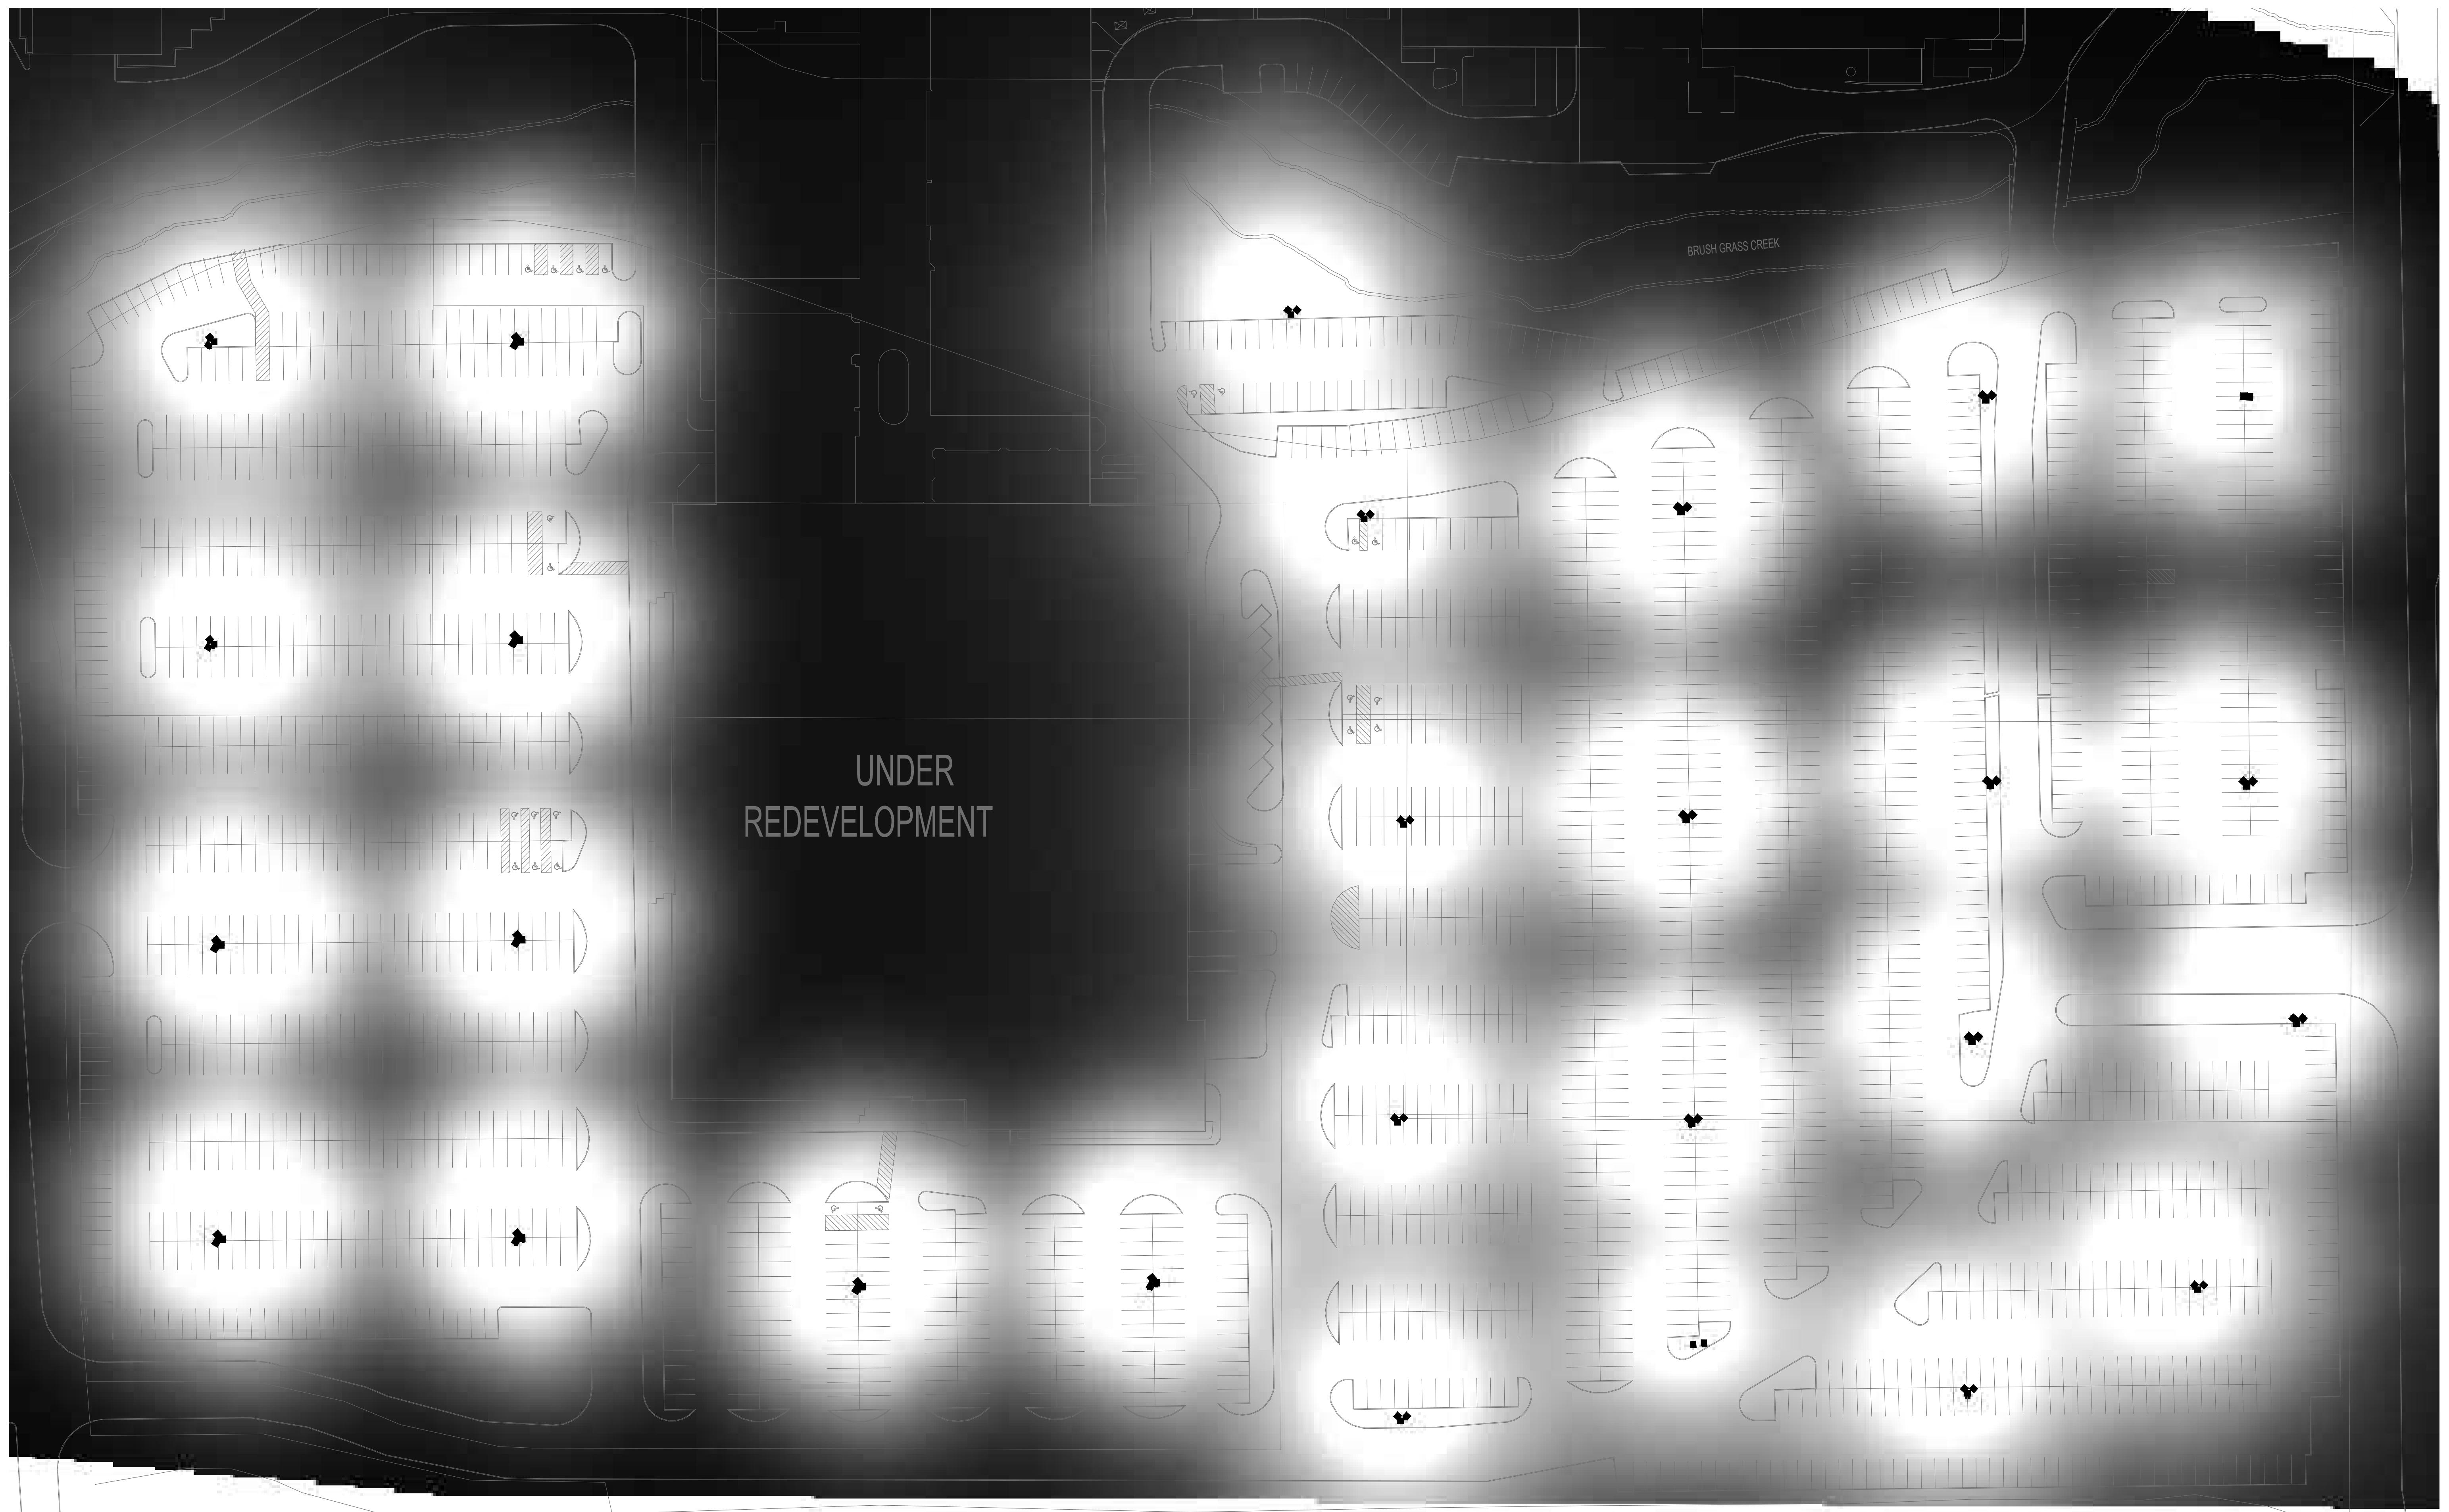

1 EXISTING PHOTOMETRIC CONTOUR SHADING PLAN


SCALE: 1" = 50'-0"

S A B A K , W I L S O N & L I N G O , I N C

ENGINERS, LANDSCAPE ARCHITECTS & PLANNERS
THE HENRY CLAY 608 S. THIRD STREET, LOUISVILLE, KENTUCKY 40202
(502) 584 - 6271

DHTA
ENGINEERING
Contracting Engineers
(502) 471-7963

SHEET TITLE:		EXISTING PHOTOMETRIC CONTOUR SHADING PLAN	DATE
NO.	REVISION	.	.
PROJECT TITLE:		TOP GOLF AT OXMOOR CENTER	
		7900 SHELBYVILLE ROAD & OXMOOR LANE	
		LOUISVILLE, KY 40222	
		T.B. 89N, LOTS 1, 3, & 7 AND T.B. 89M, LOTS 50 & 51	
JOB NO.		3096	
SCALE:		1"=50'	
DATE:		05/23/18	
DRAWING NO: 1-1			

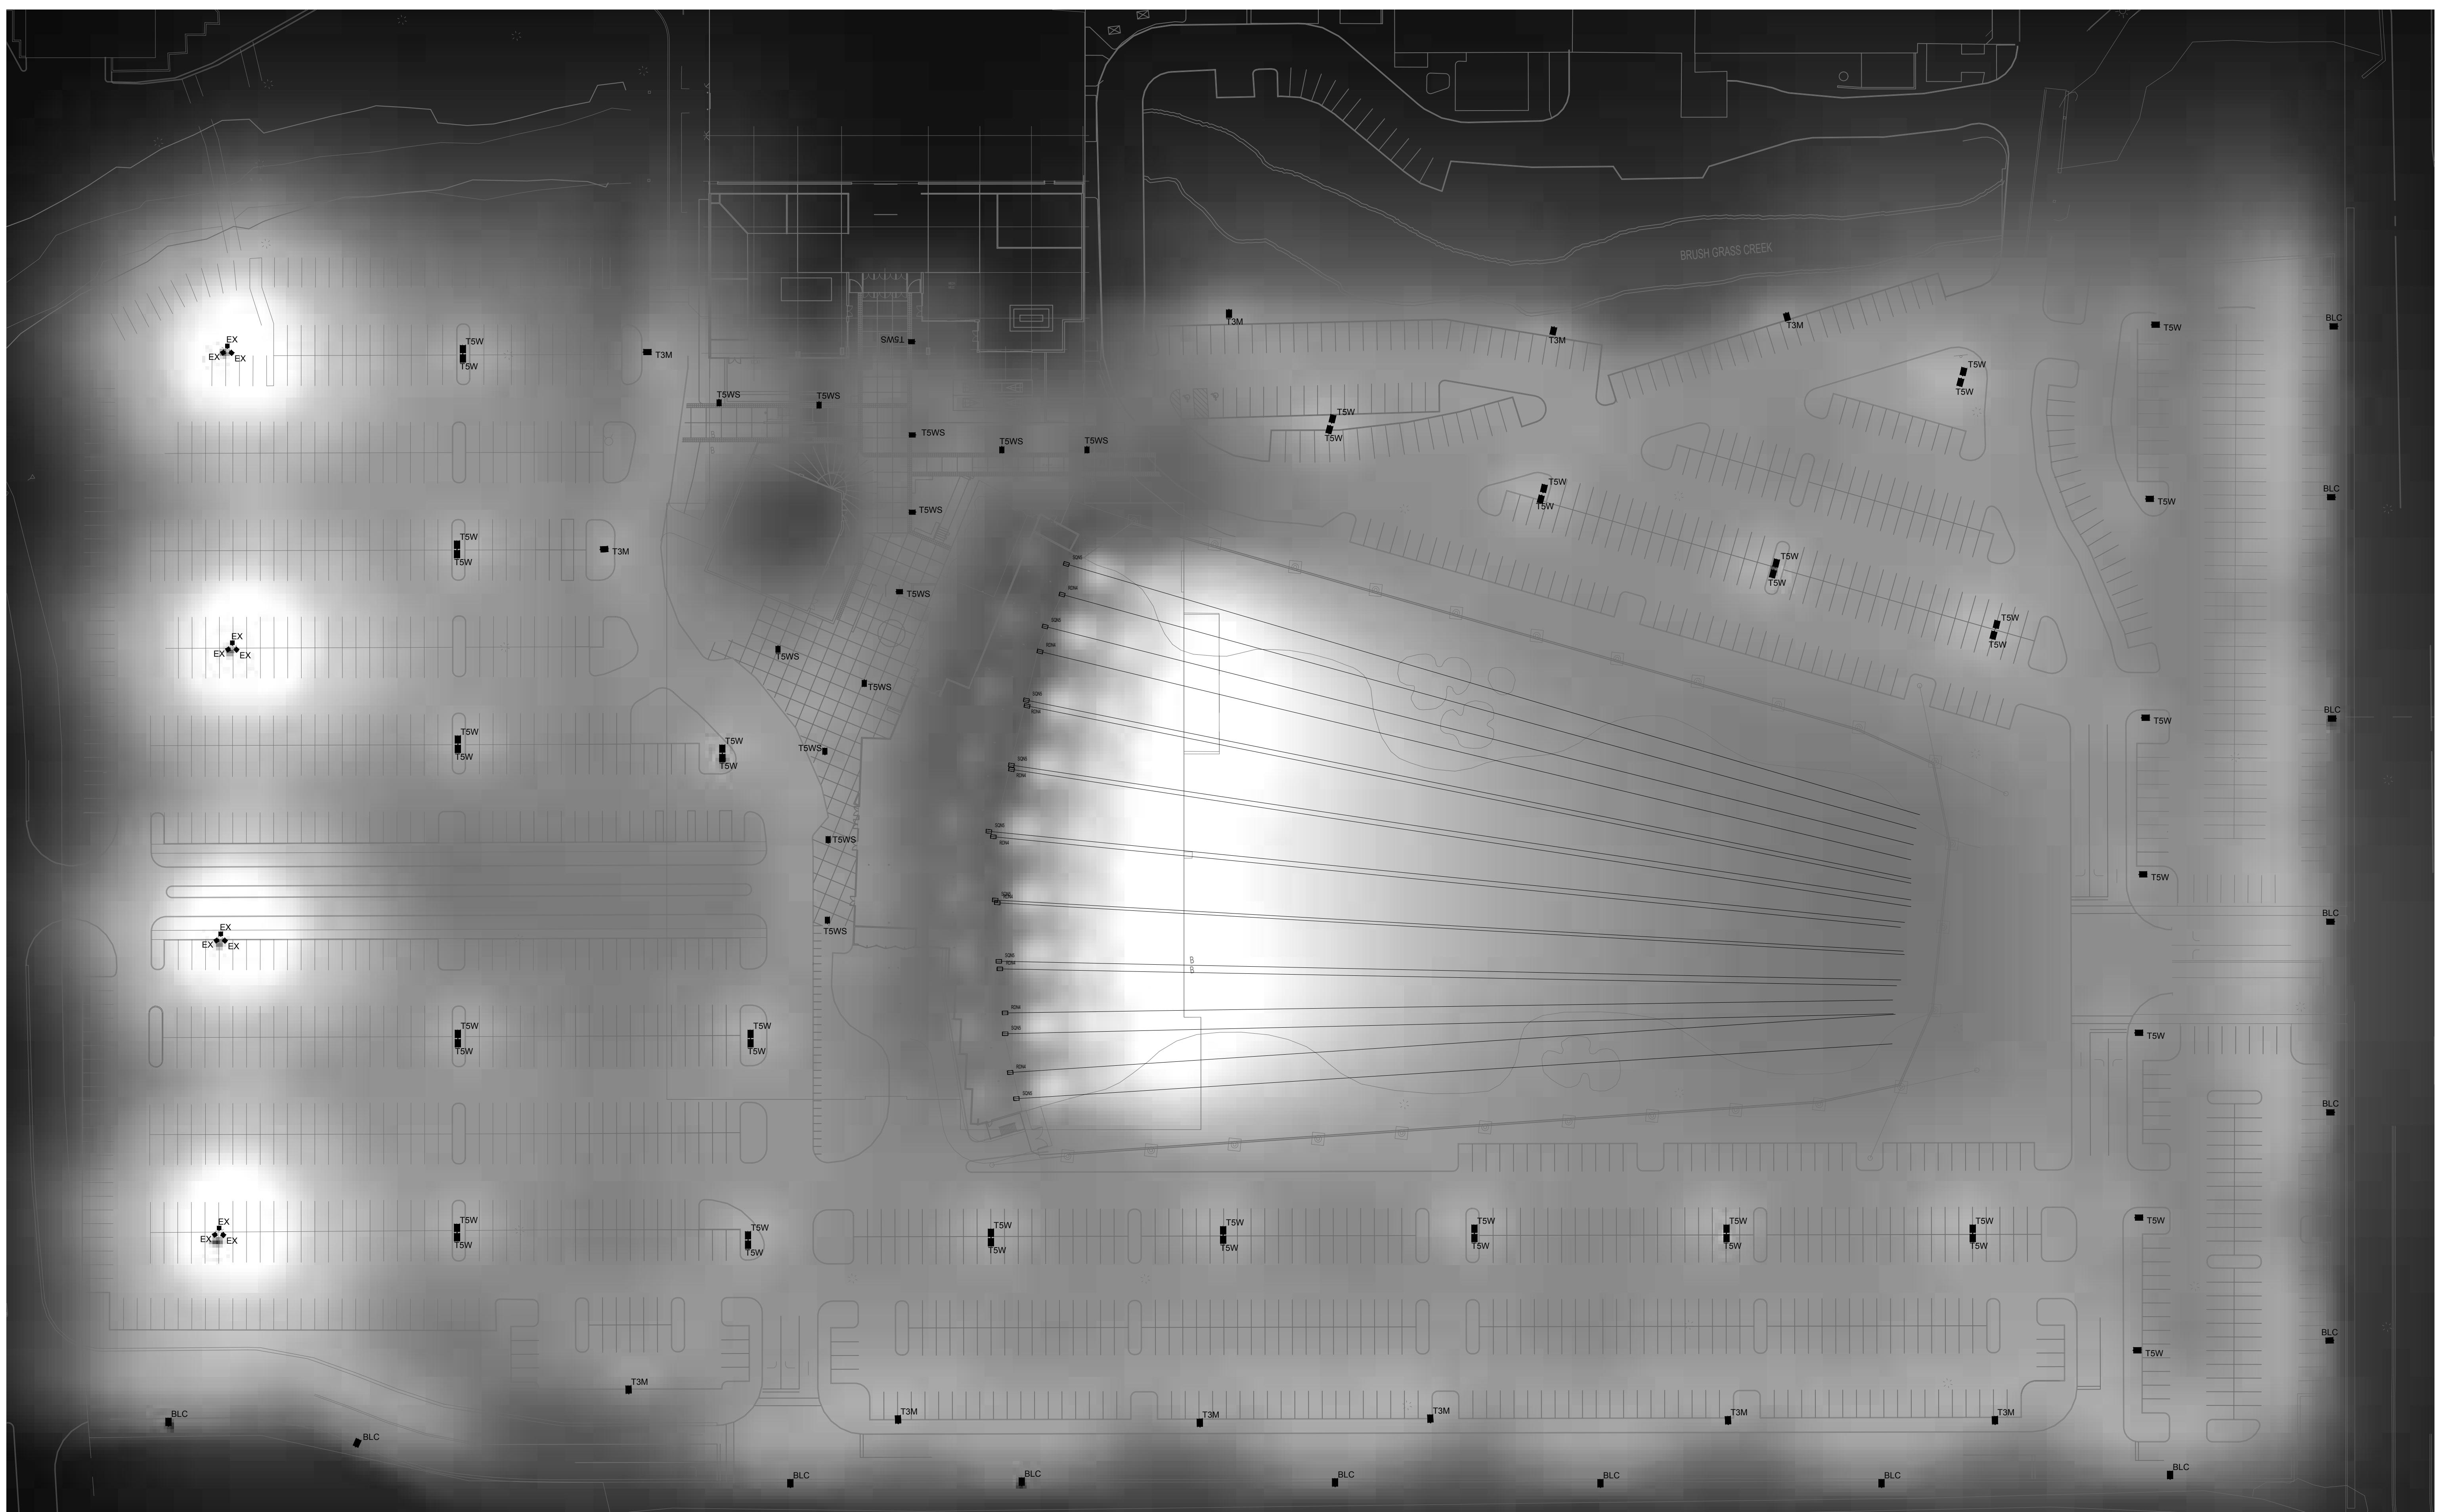

1

NEW PHOTOMETRIC CONTOUR SHADING PLAN

SCALE: 1" = 50'-0"

CASE # 182ZONE1014

OWNER
WMB 2, LLC & OXMOOR 2, LLC.
PO BOX 97905
CHICAGO, IL 60661
D.B. 10972, PG. 183

APPLICANTS
TOPGOLF USA LOUISVILLE, LLC
8750 N. CENTRAL EXPRESSWAY, STE. 1200
DALLAS, TX 75231

GGP INC.
350 N. ORLEANS STREET, SUITE 300
CHICAGO, IL 60654

SHEET TITLE:

NEW PHOTOMETRIC CONTOUR
SHADING PLAN

PROJECT TITLE:

TOP GOLF AT OXMOOR CENTER
LOUISVILLE, KY 40222
7900 SHELBYVILLE ROAD & OXMOOR LANE
TB. 89N, LOTS 1, 3, & 7 AND TB. 89M, LOTS 50 & 51

OWNER

JOB NO. 3096

SCALE:

1"=50'

DATE:

05/23/18

DRAWING NO:

L12

SHEET 4 OF 4

SABAK, WILSON & LINGO, INC
ENGINEERS, LANDSCAPE ARCHITECTS & PLANNERS
THE HENRY CLAY
608 S. THIRD STREET,
LOUISVILLE, KENTUCKY 40202
(502) 584 - 6271



PHOTOMETRIC CONTOUR SHADING PLAN
Version 2.0
Copyright © 2002 by Photometric Solutions, Inc.